




# THE LODGE



Copyright © Campbell McLean P/L


1 ELEVATION AA  
1:50

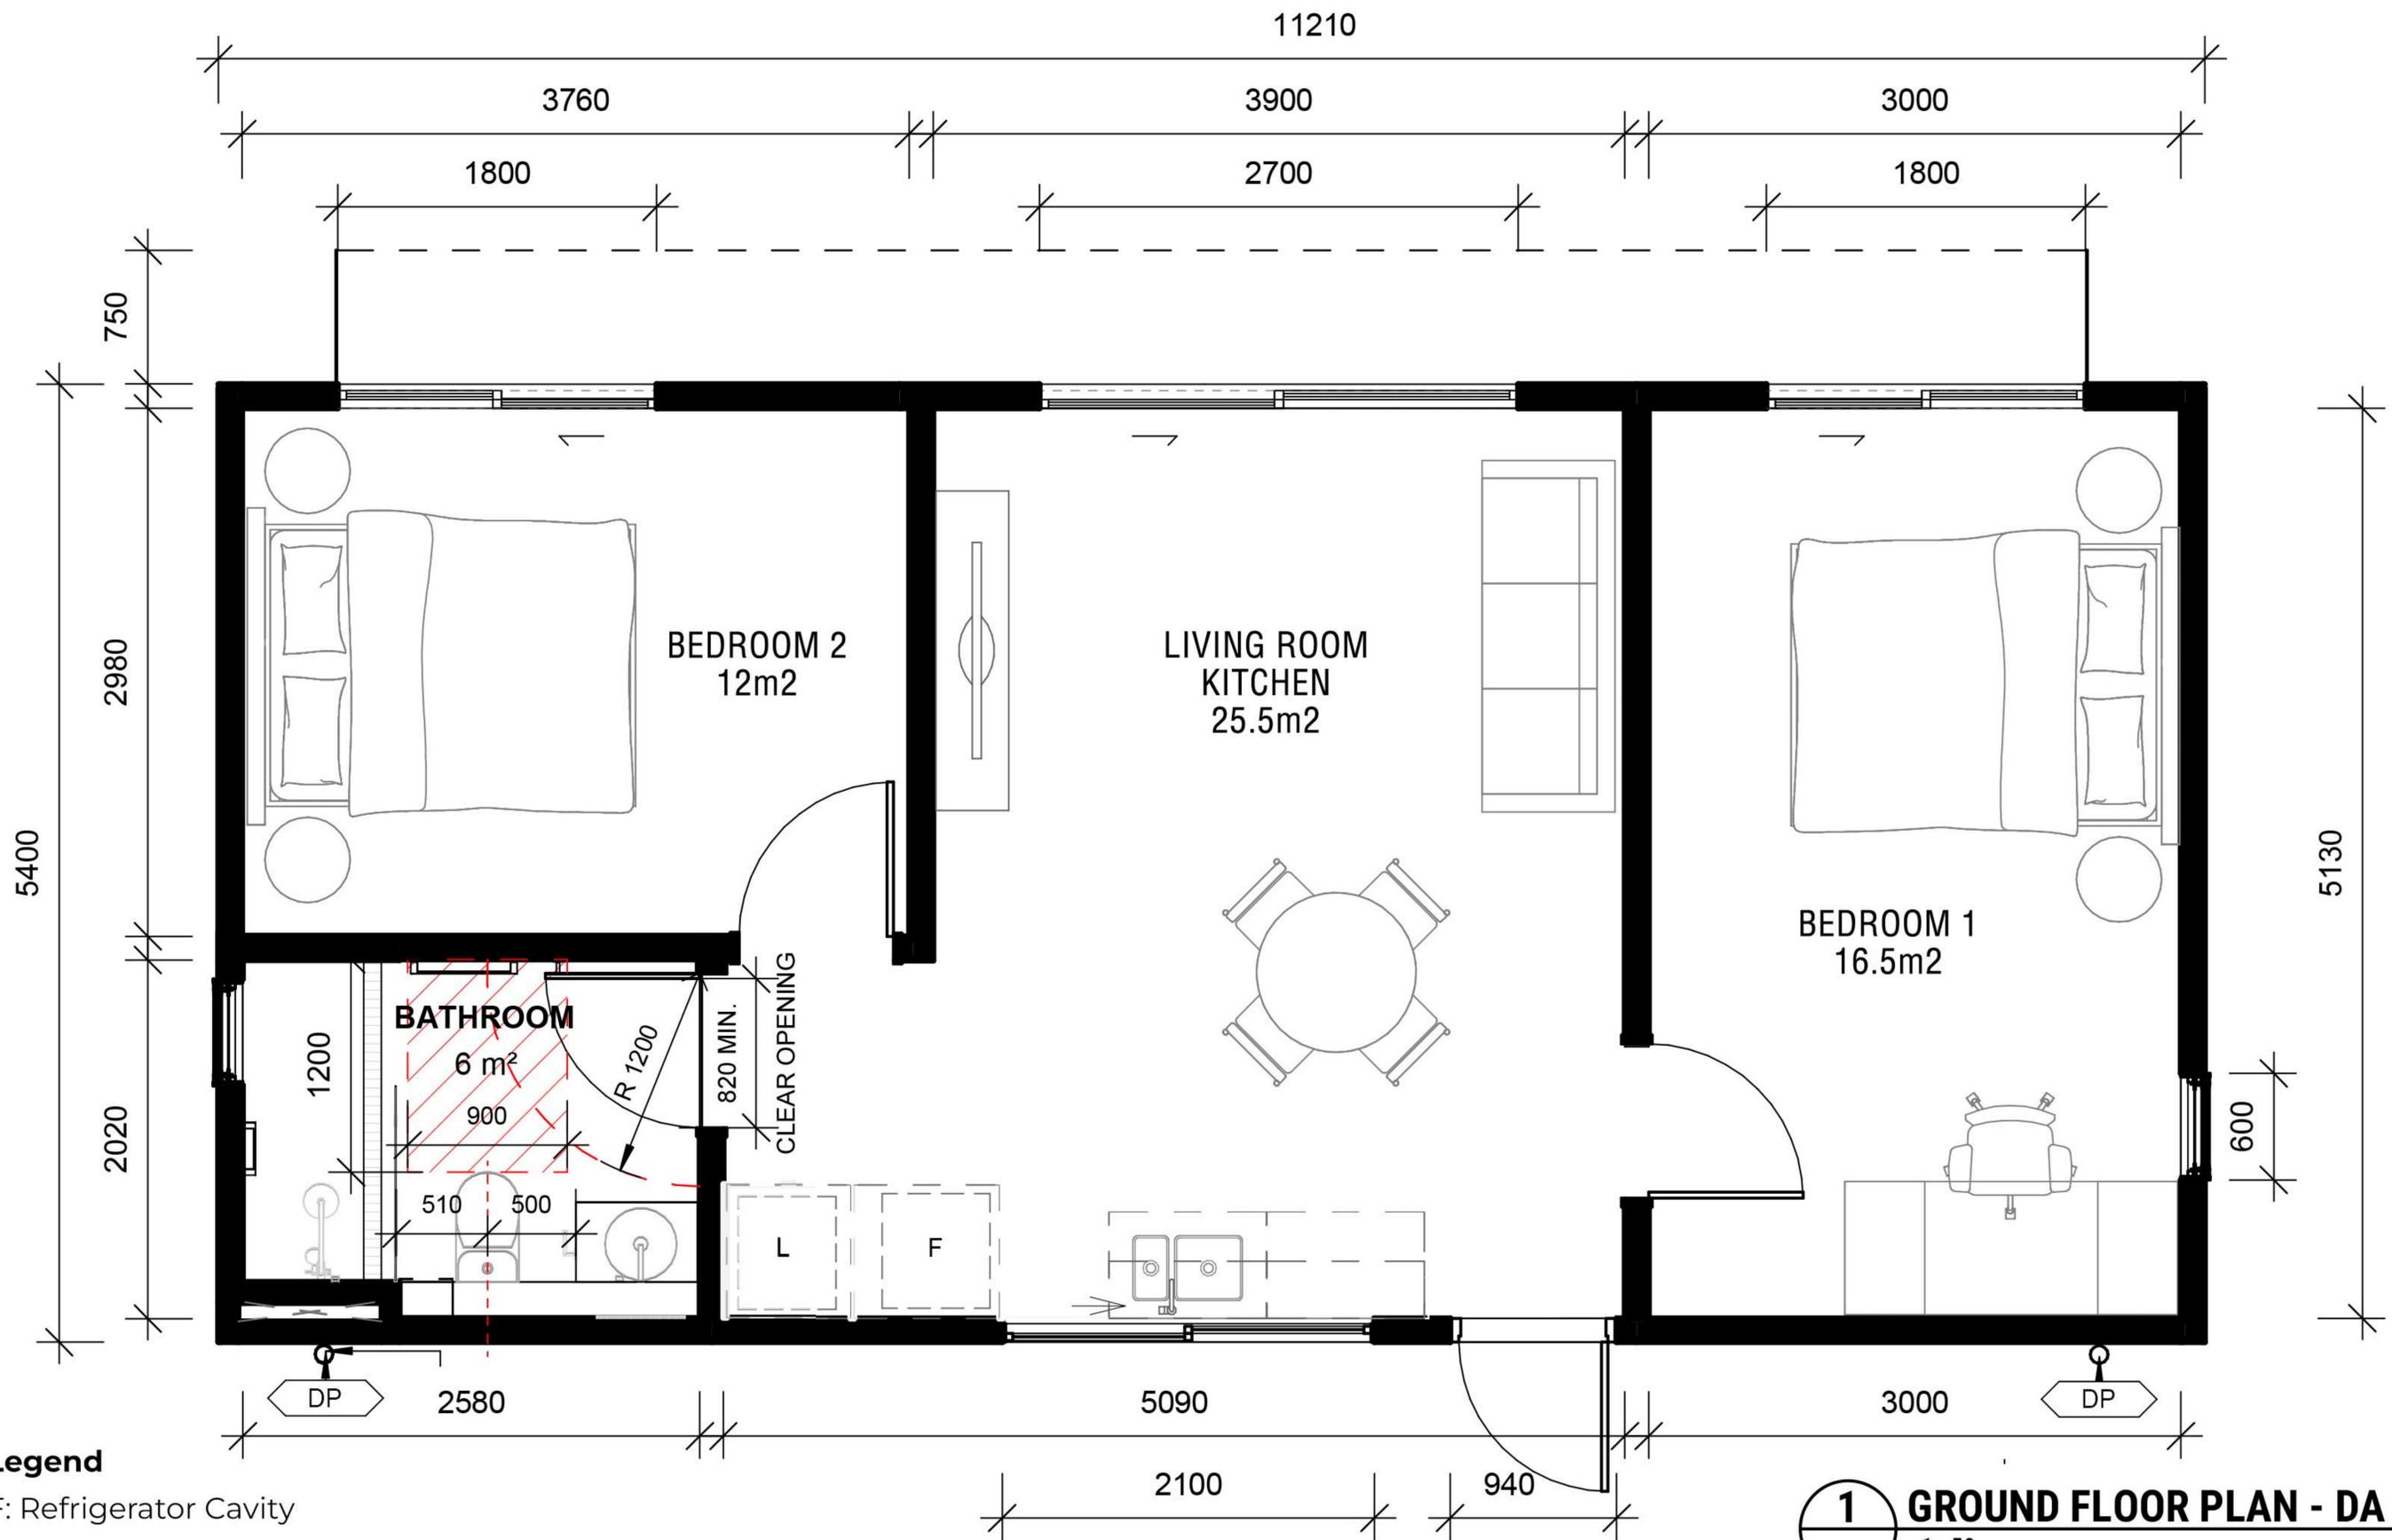


**Legend**

- F: Refrigerator Cavity
- L: European Laundry


**1 GROUND FLOOR PLAN - DA**  
1 : 50

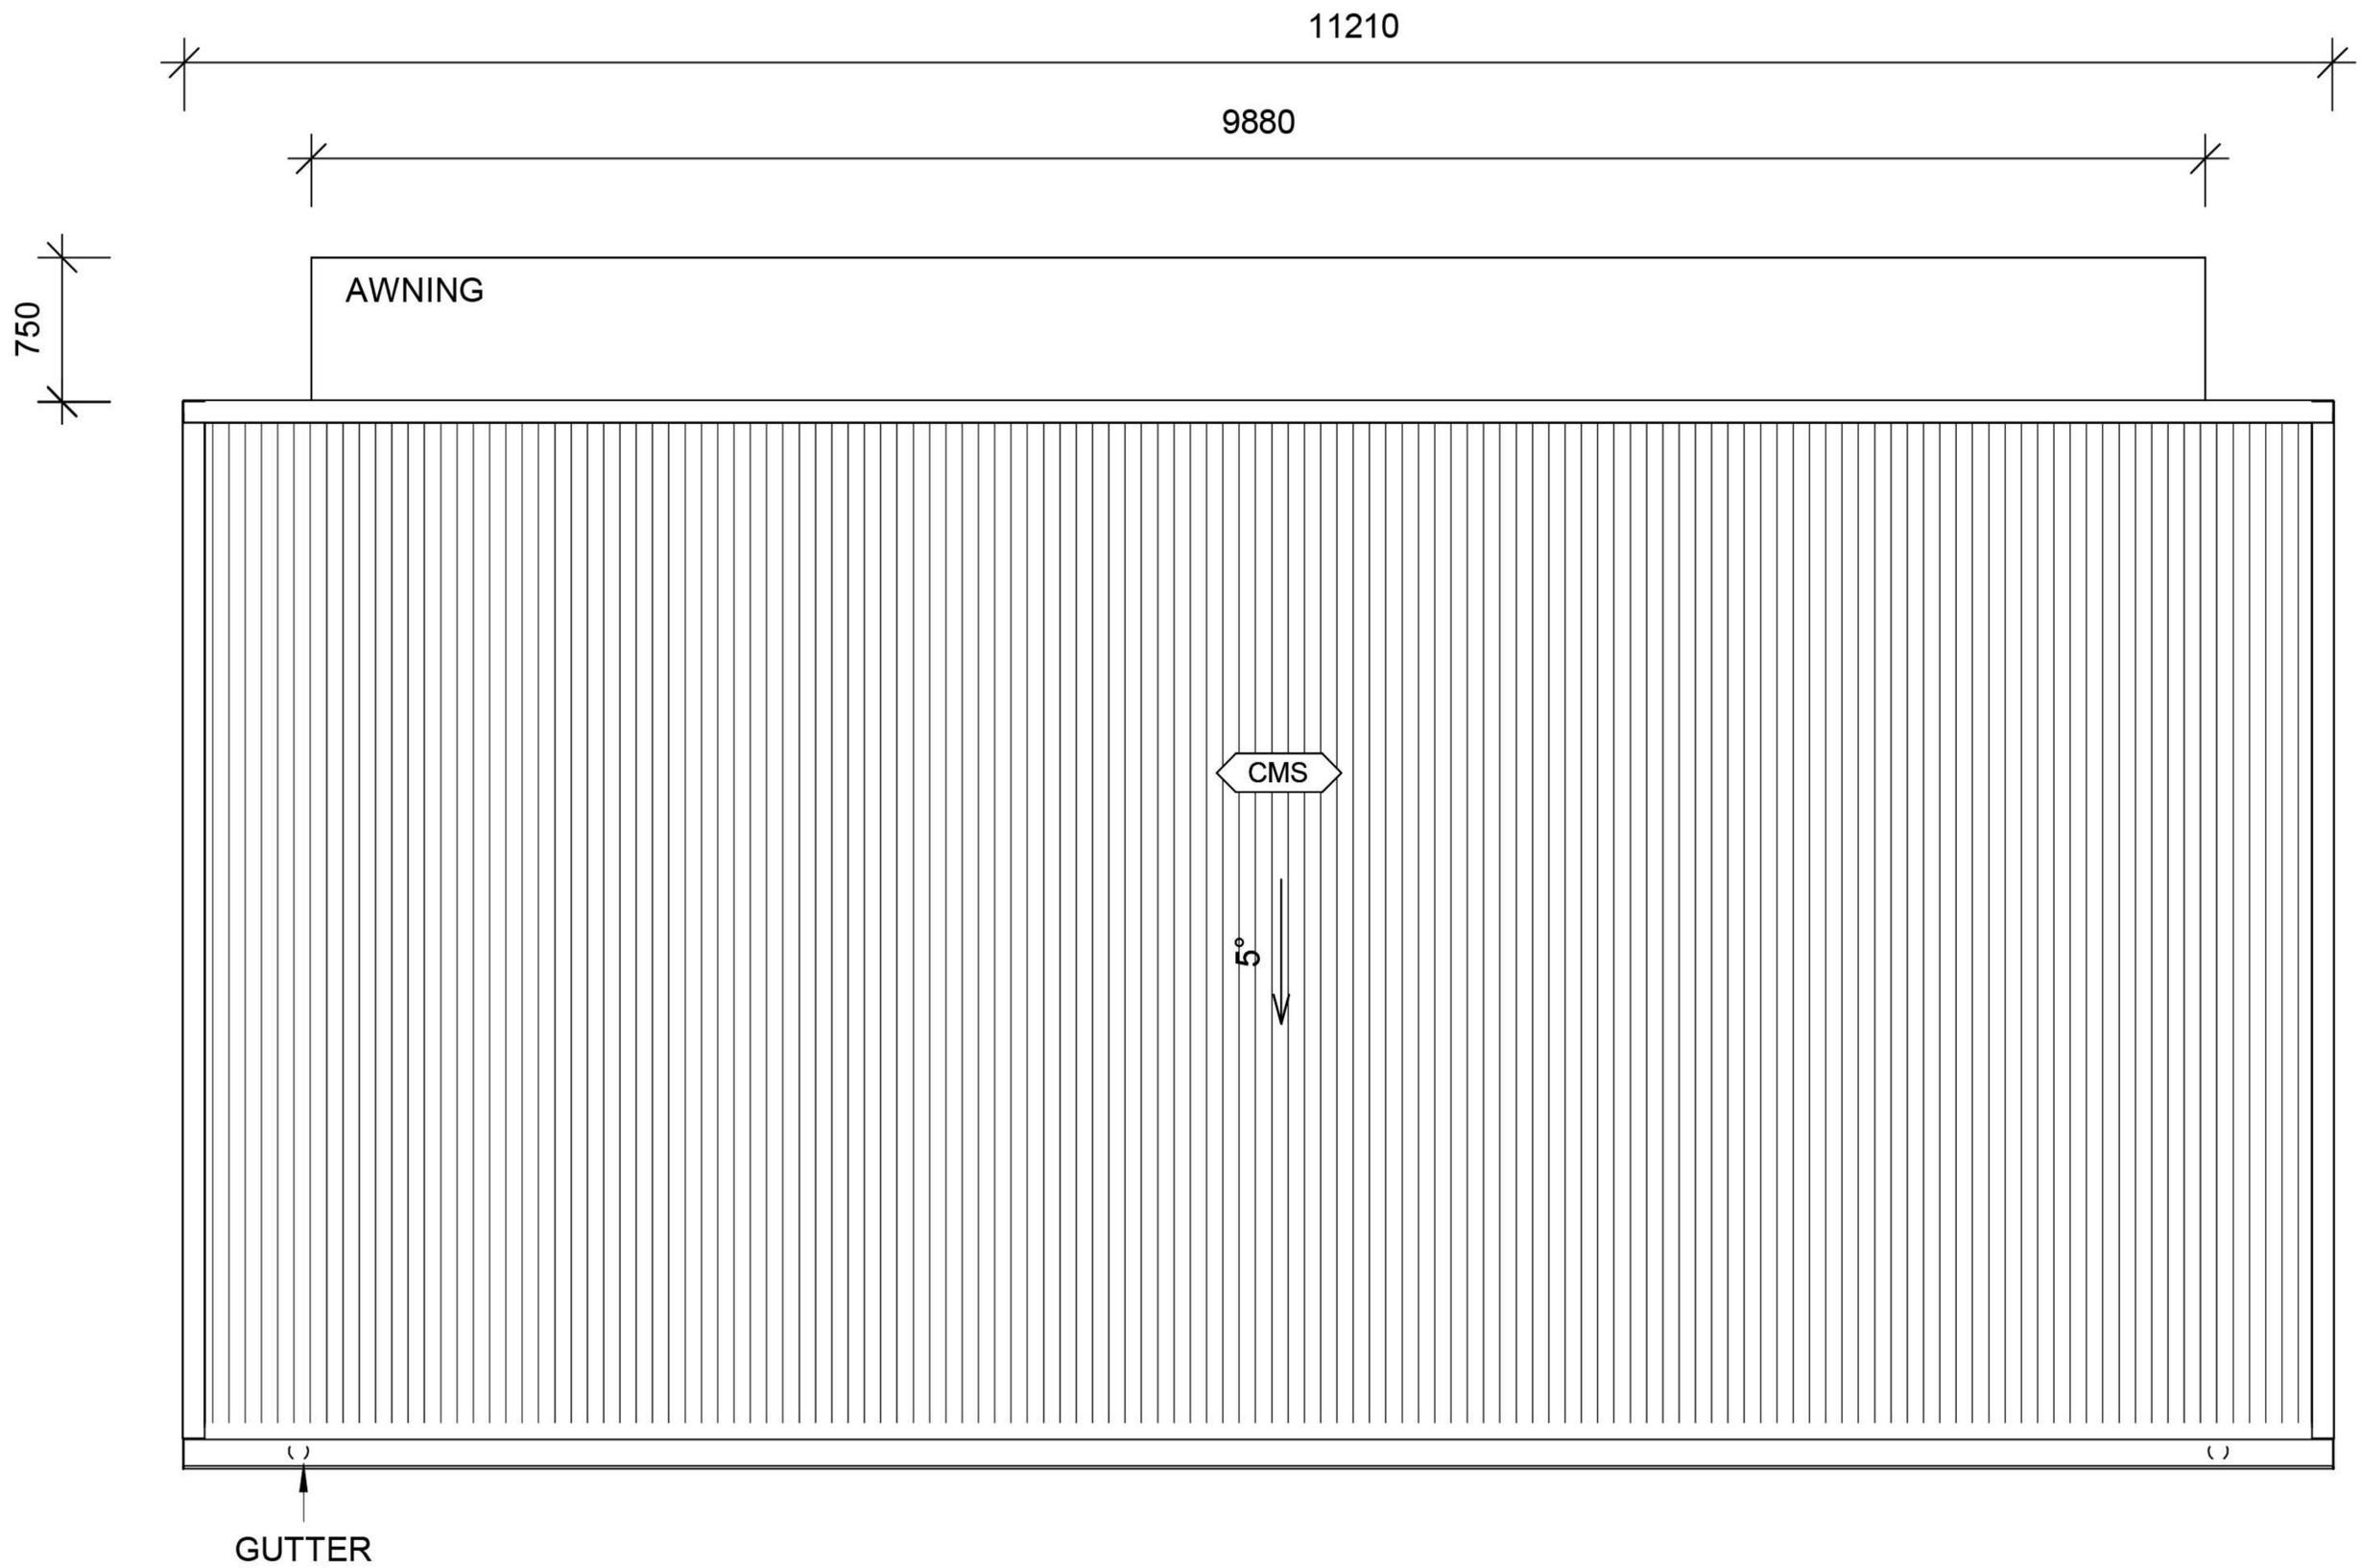


**1** ROOF PLAN - DA  
1 : 50

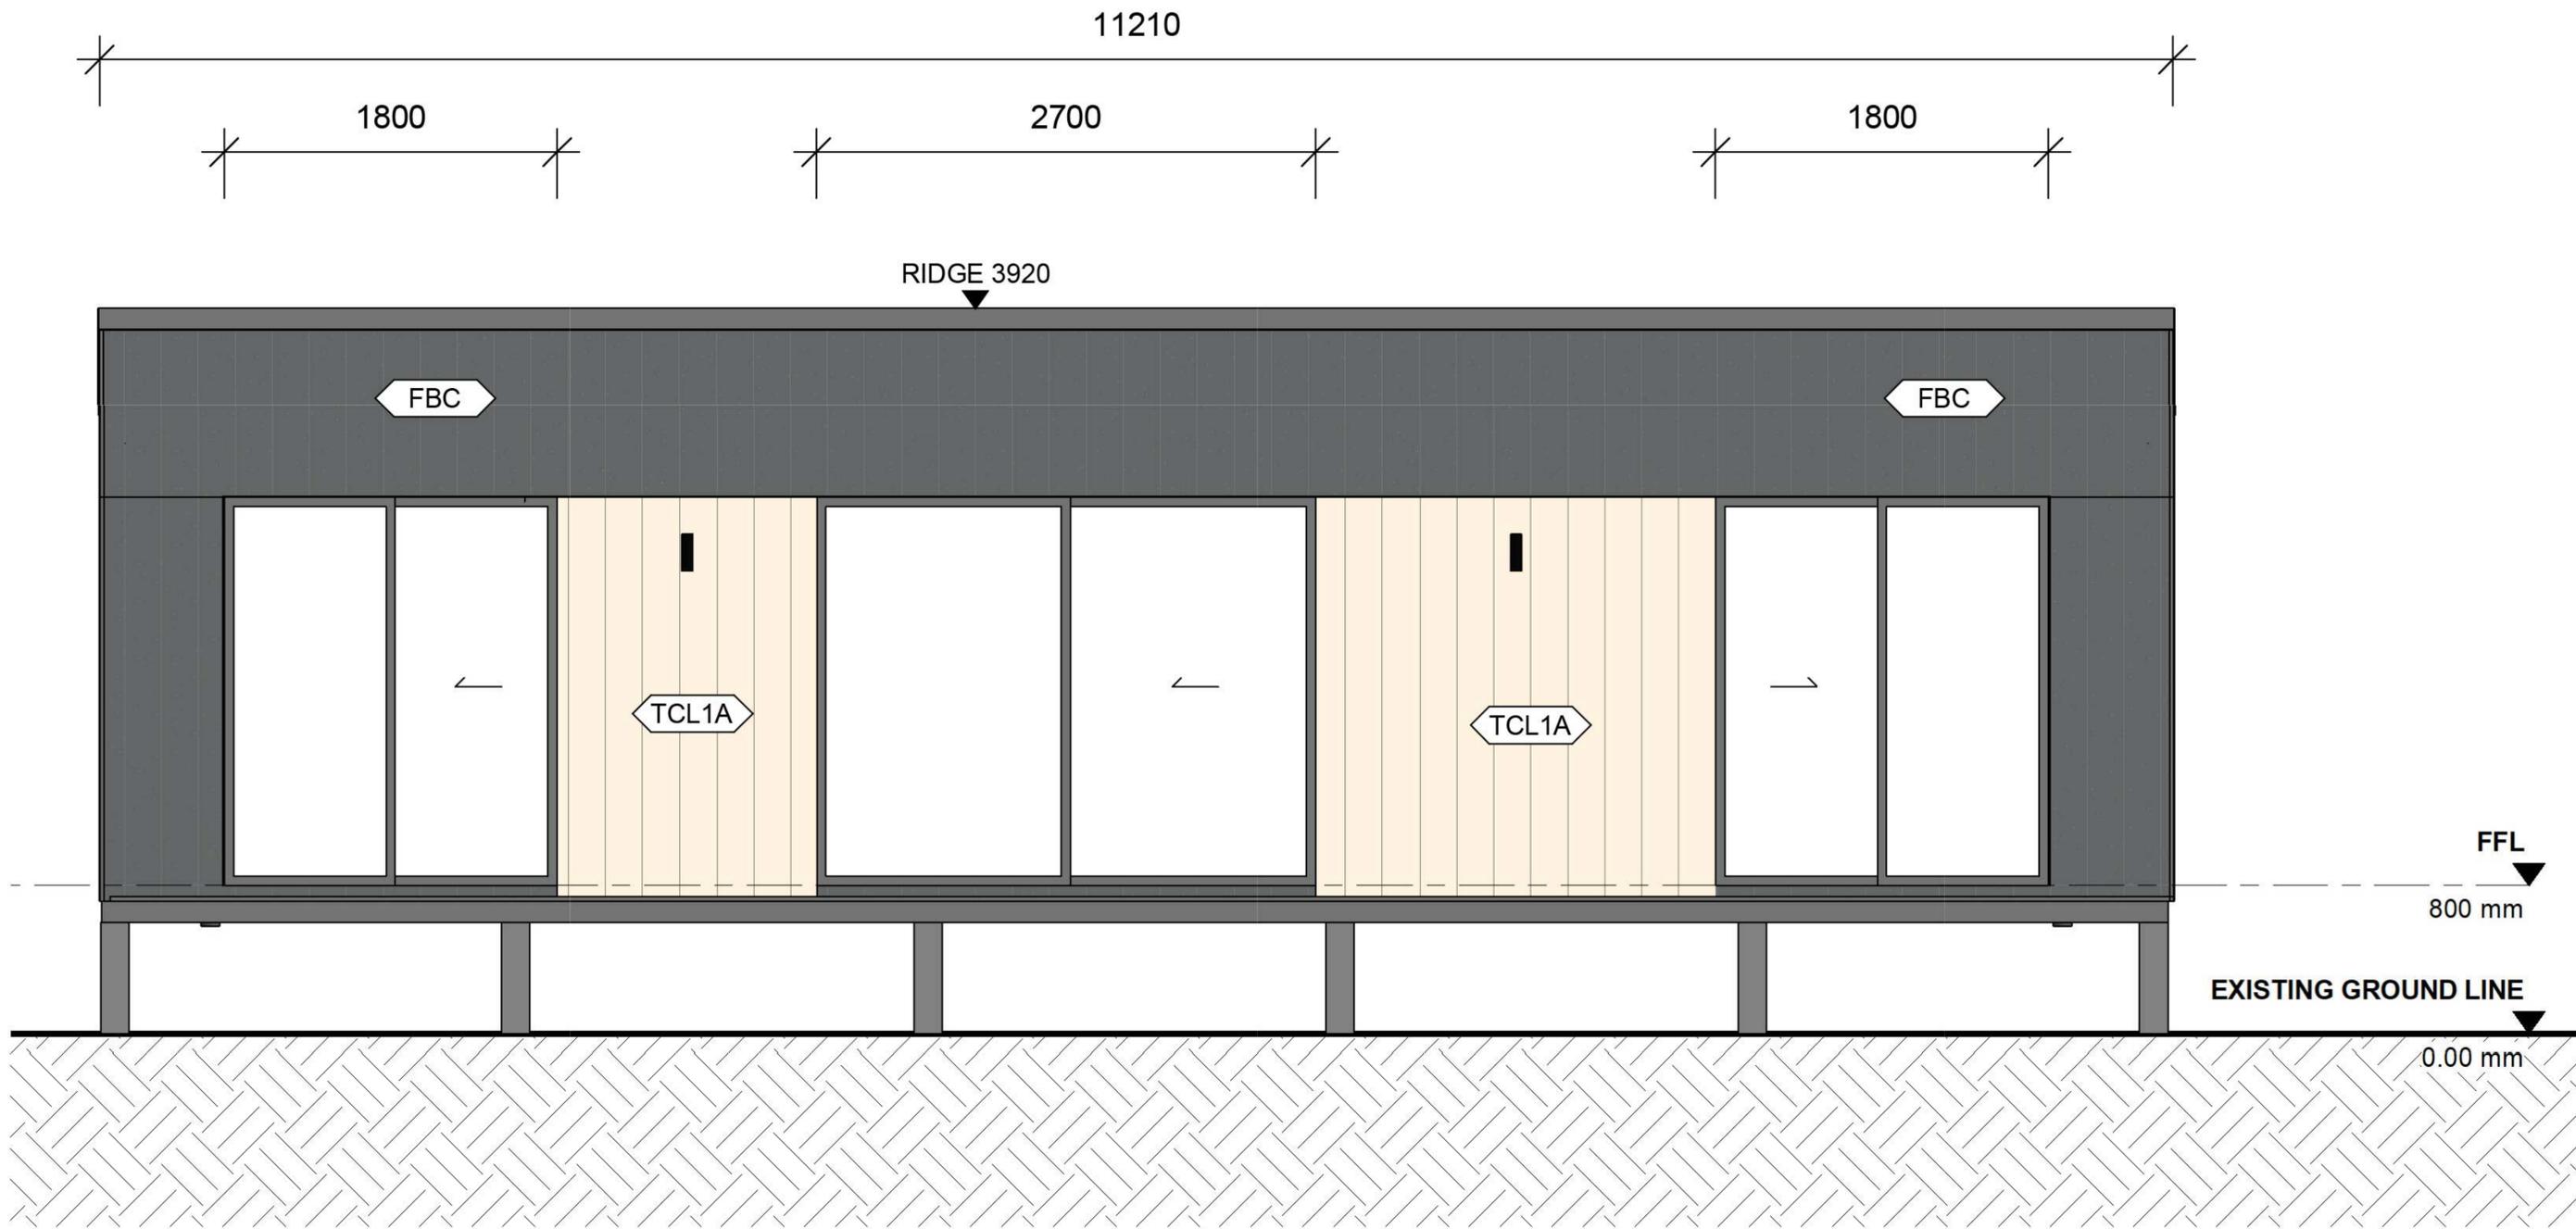


**1** ELEVATION AA - DA  
1 : 50

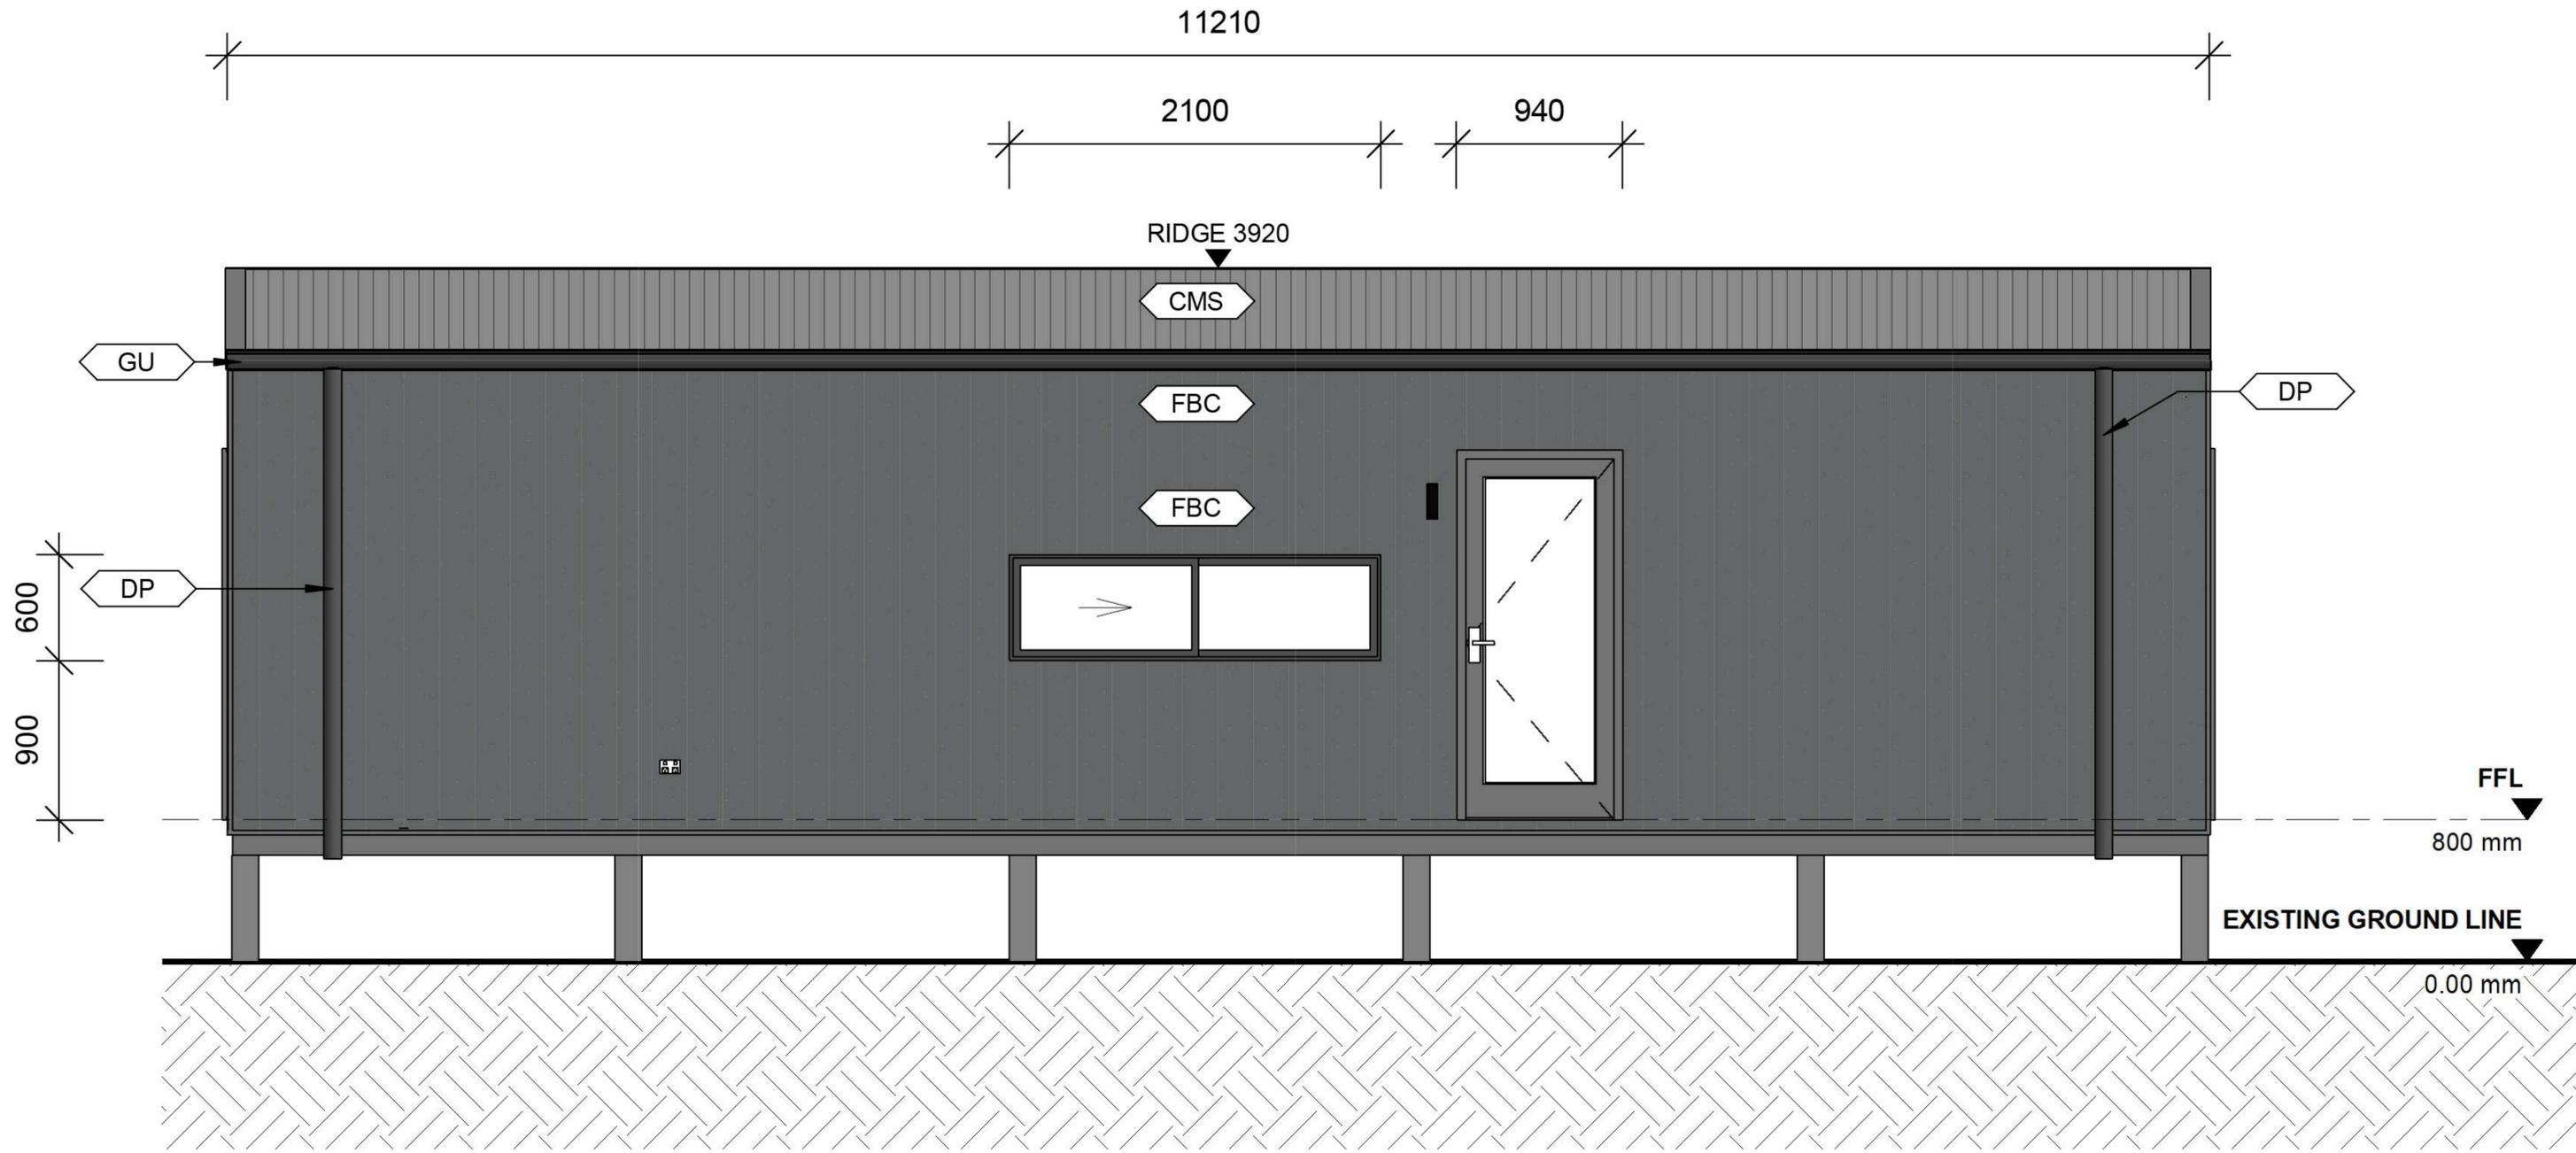


**1** ELEVATION CC - DA  
1 : 50

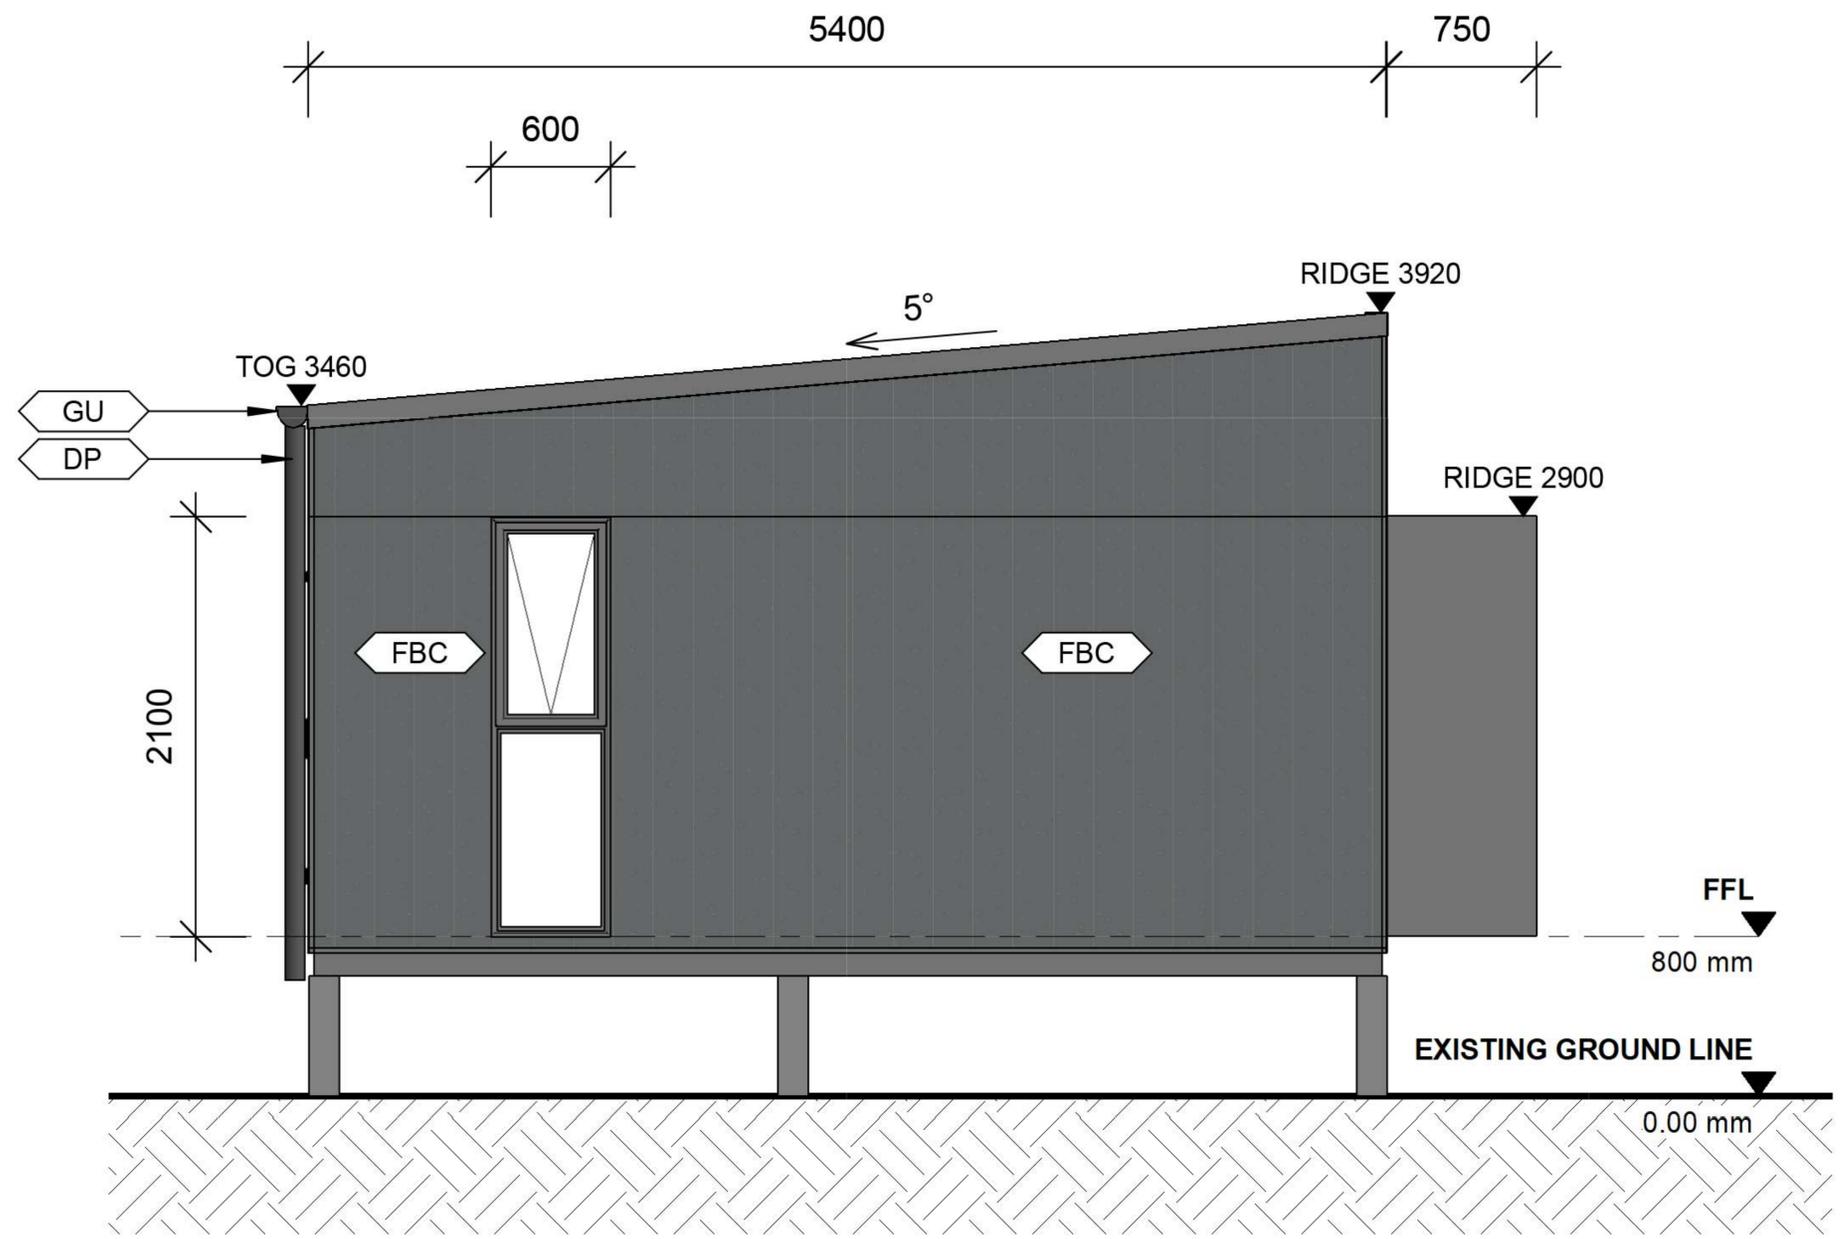


**1** ELEVATION BB - DA  
1 : 50

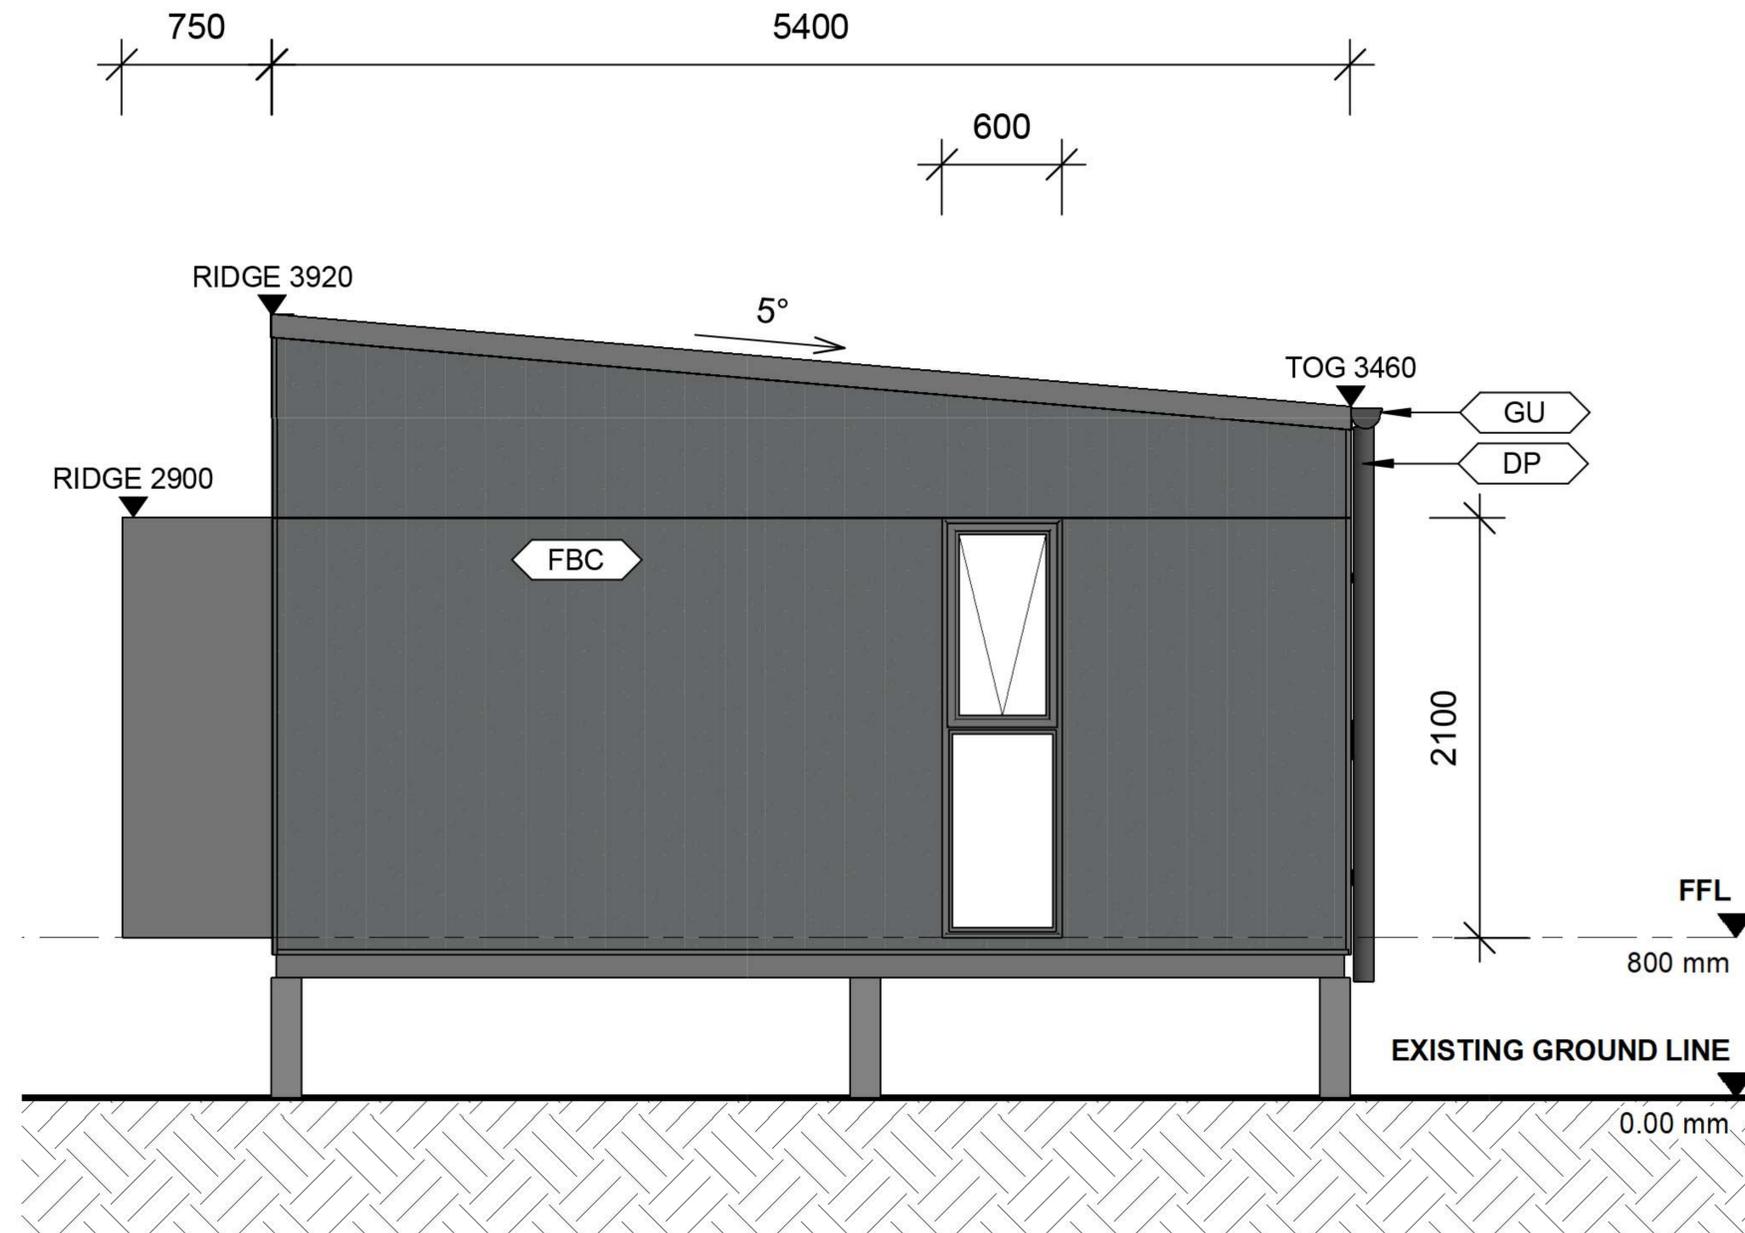


**2** ELEVATION DD - DA  
1 : 50

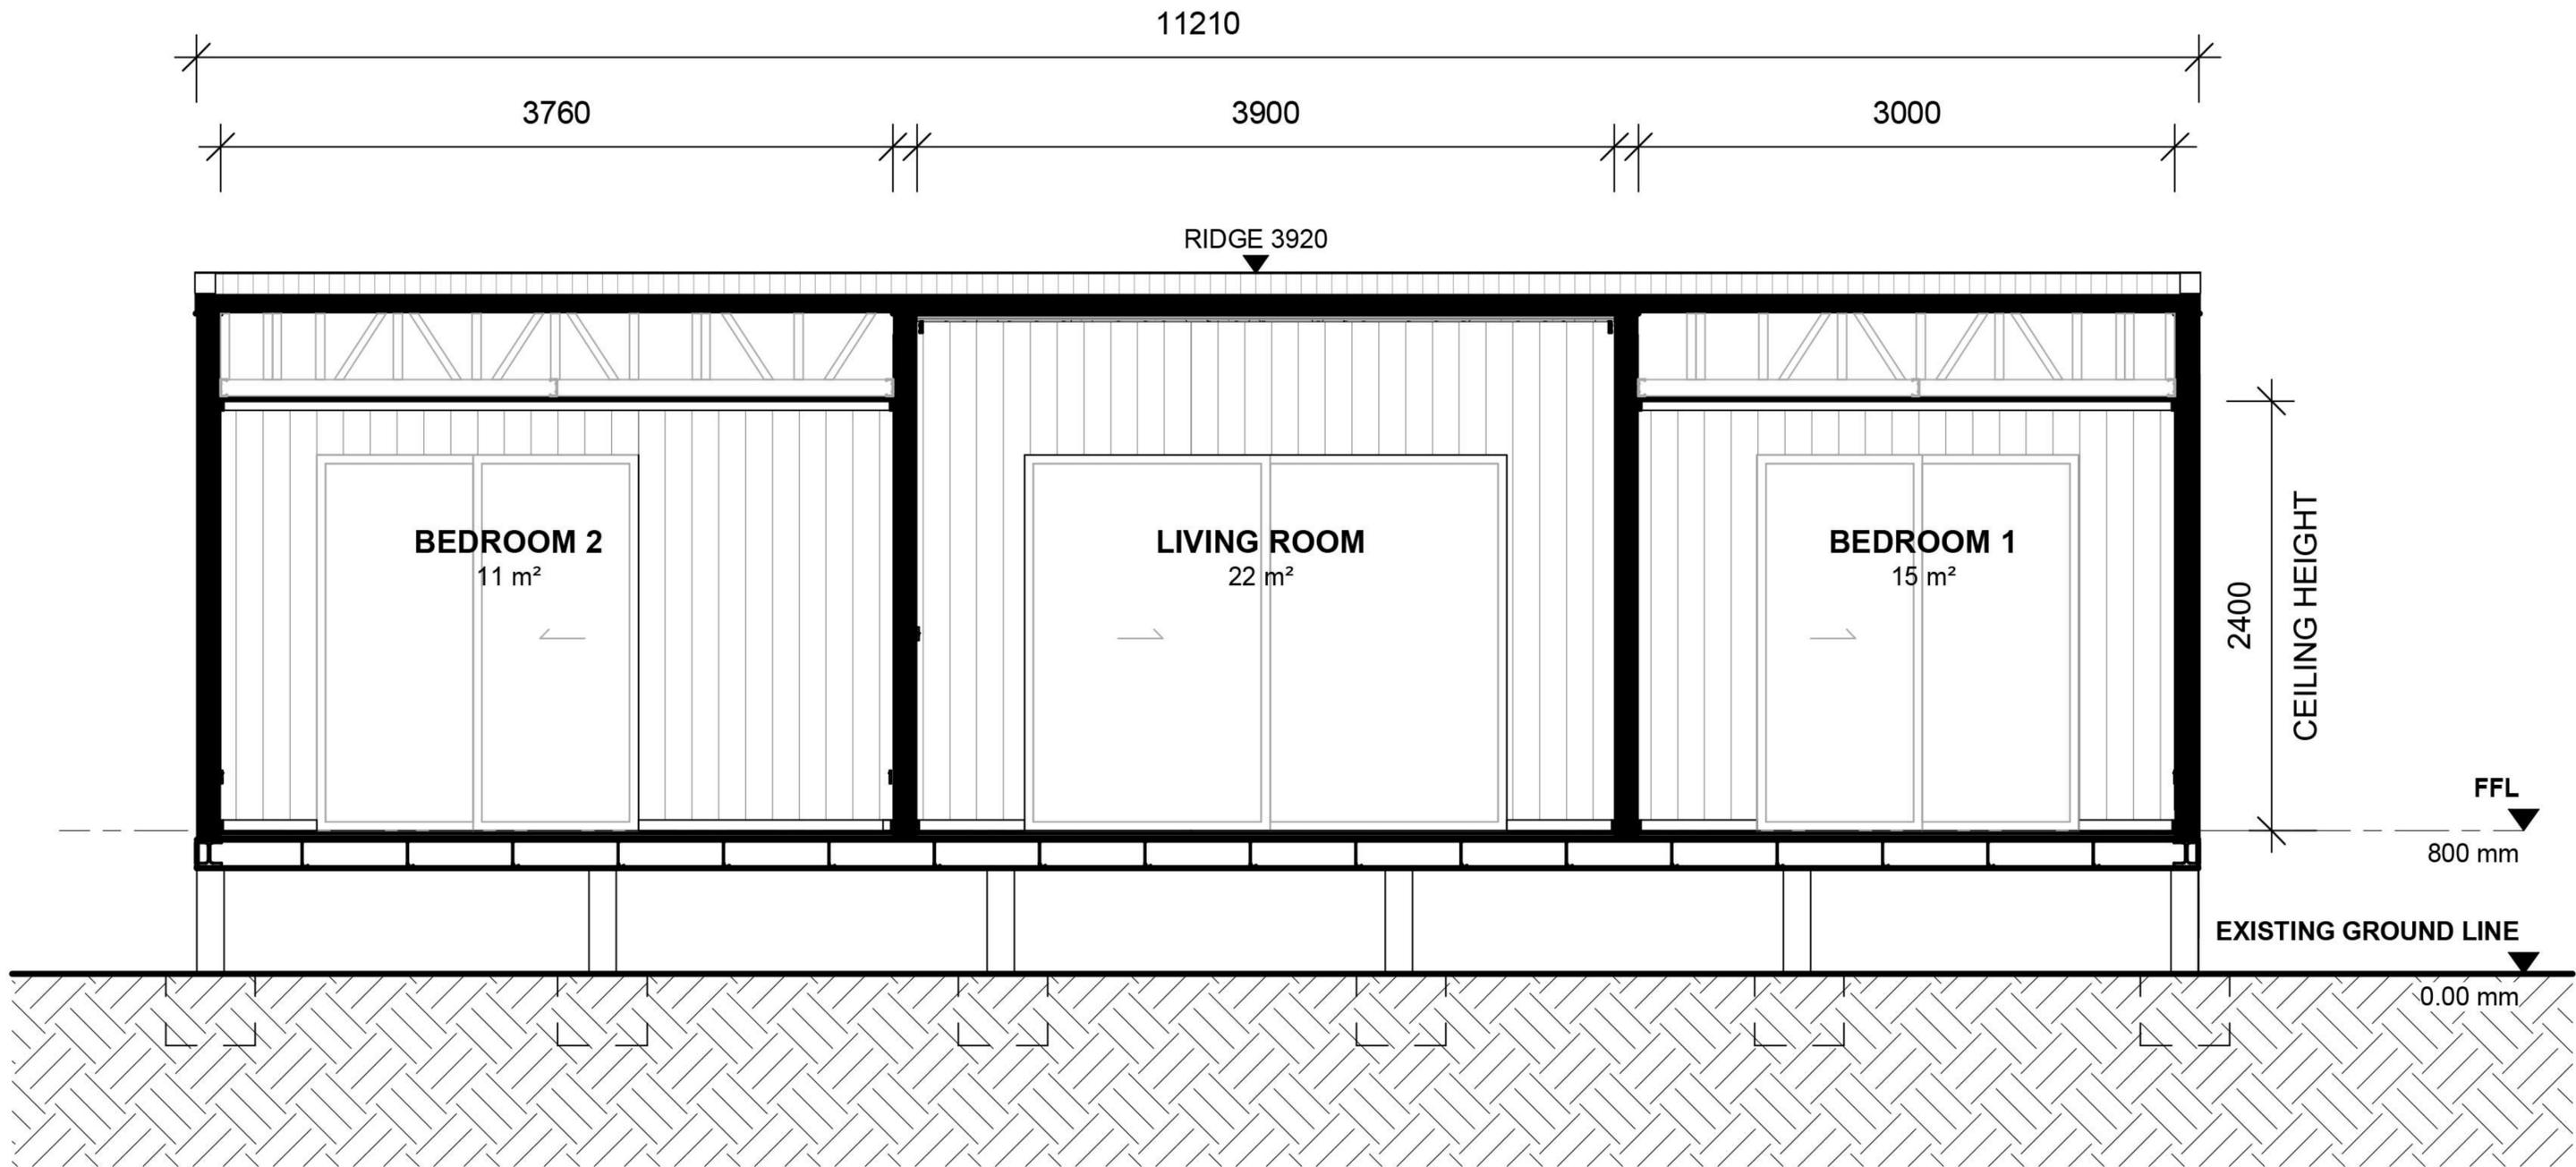

**1** SECTION 1 - DA  
1 : 50

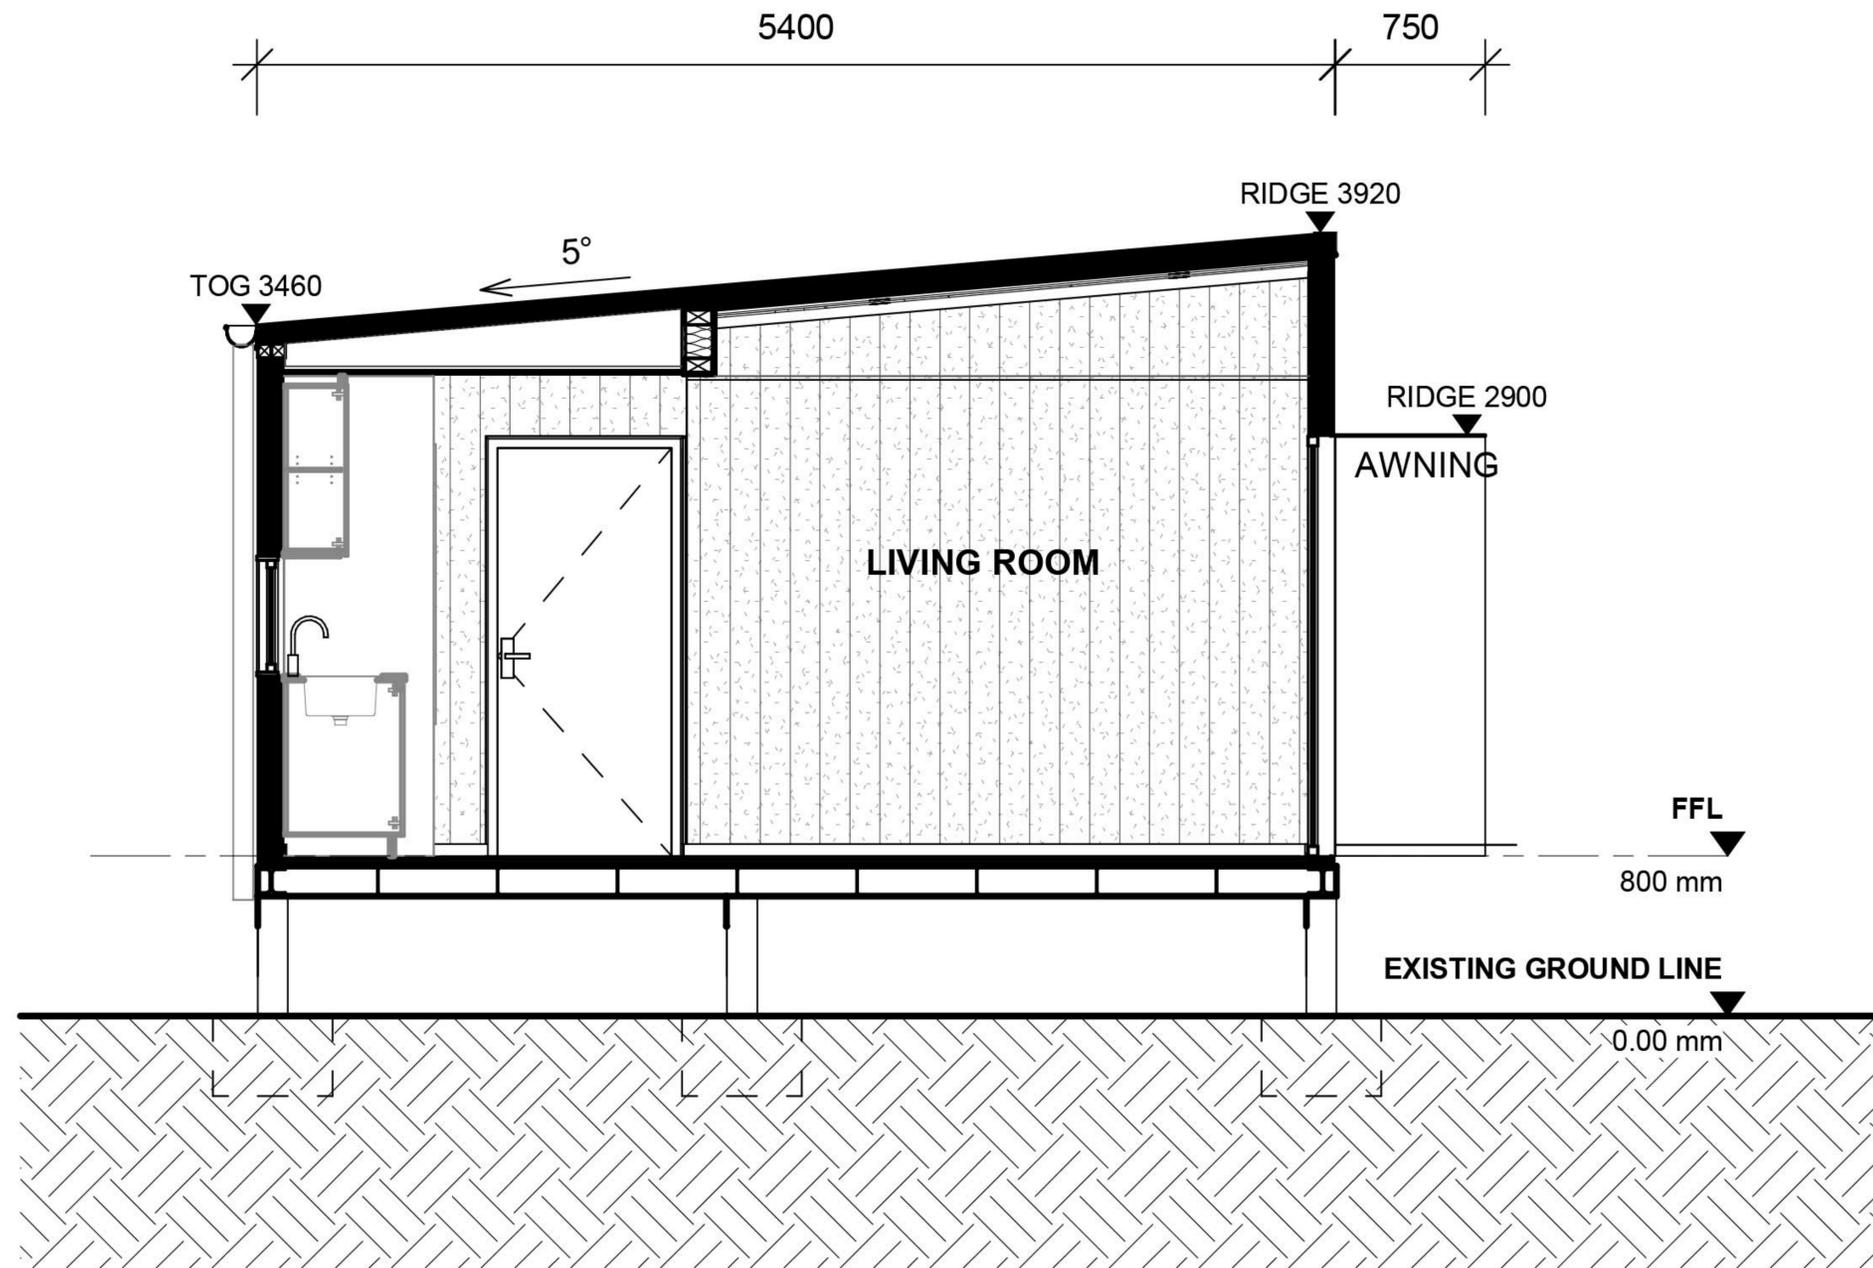

**1** SECTION 2 - DA  
1 : 50

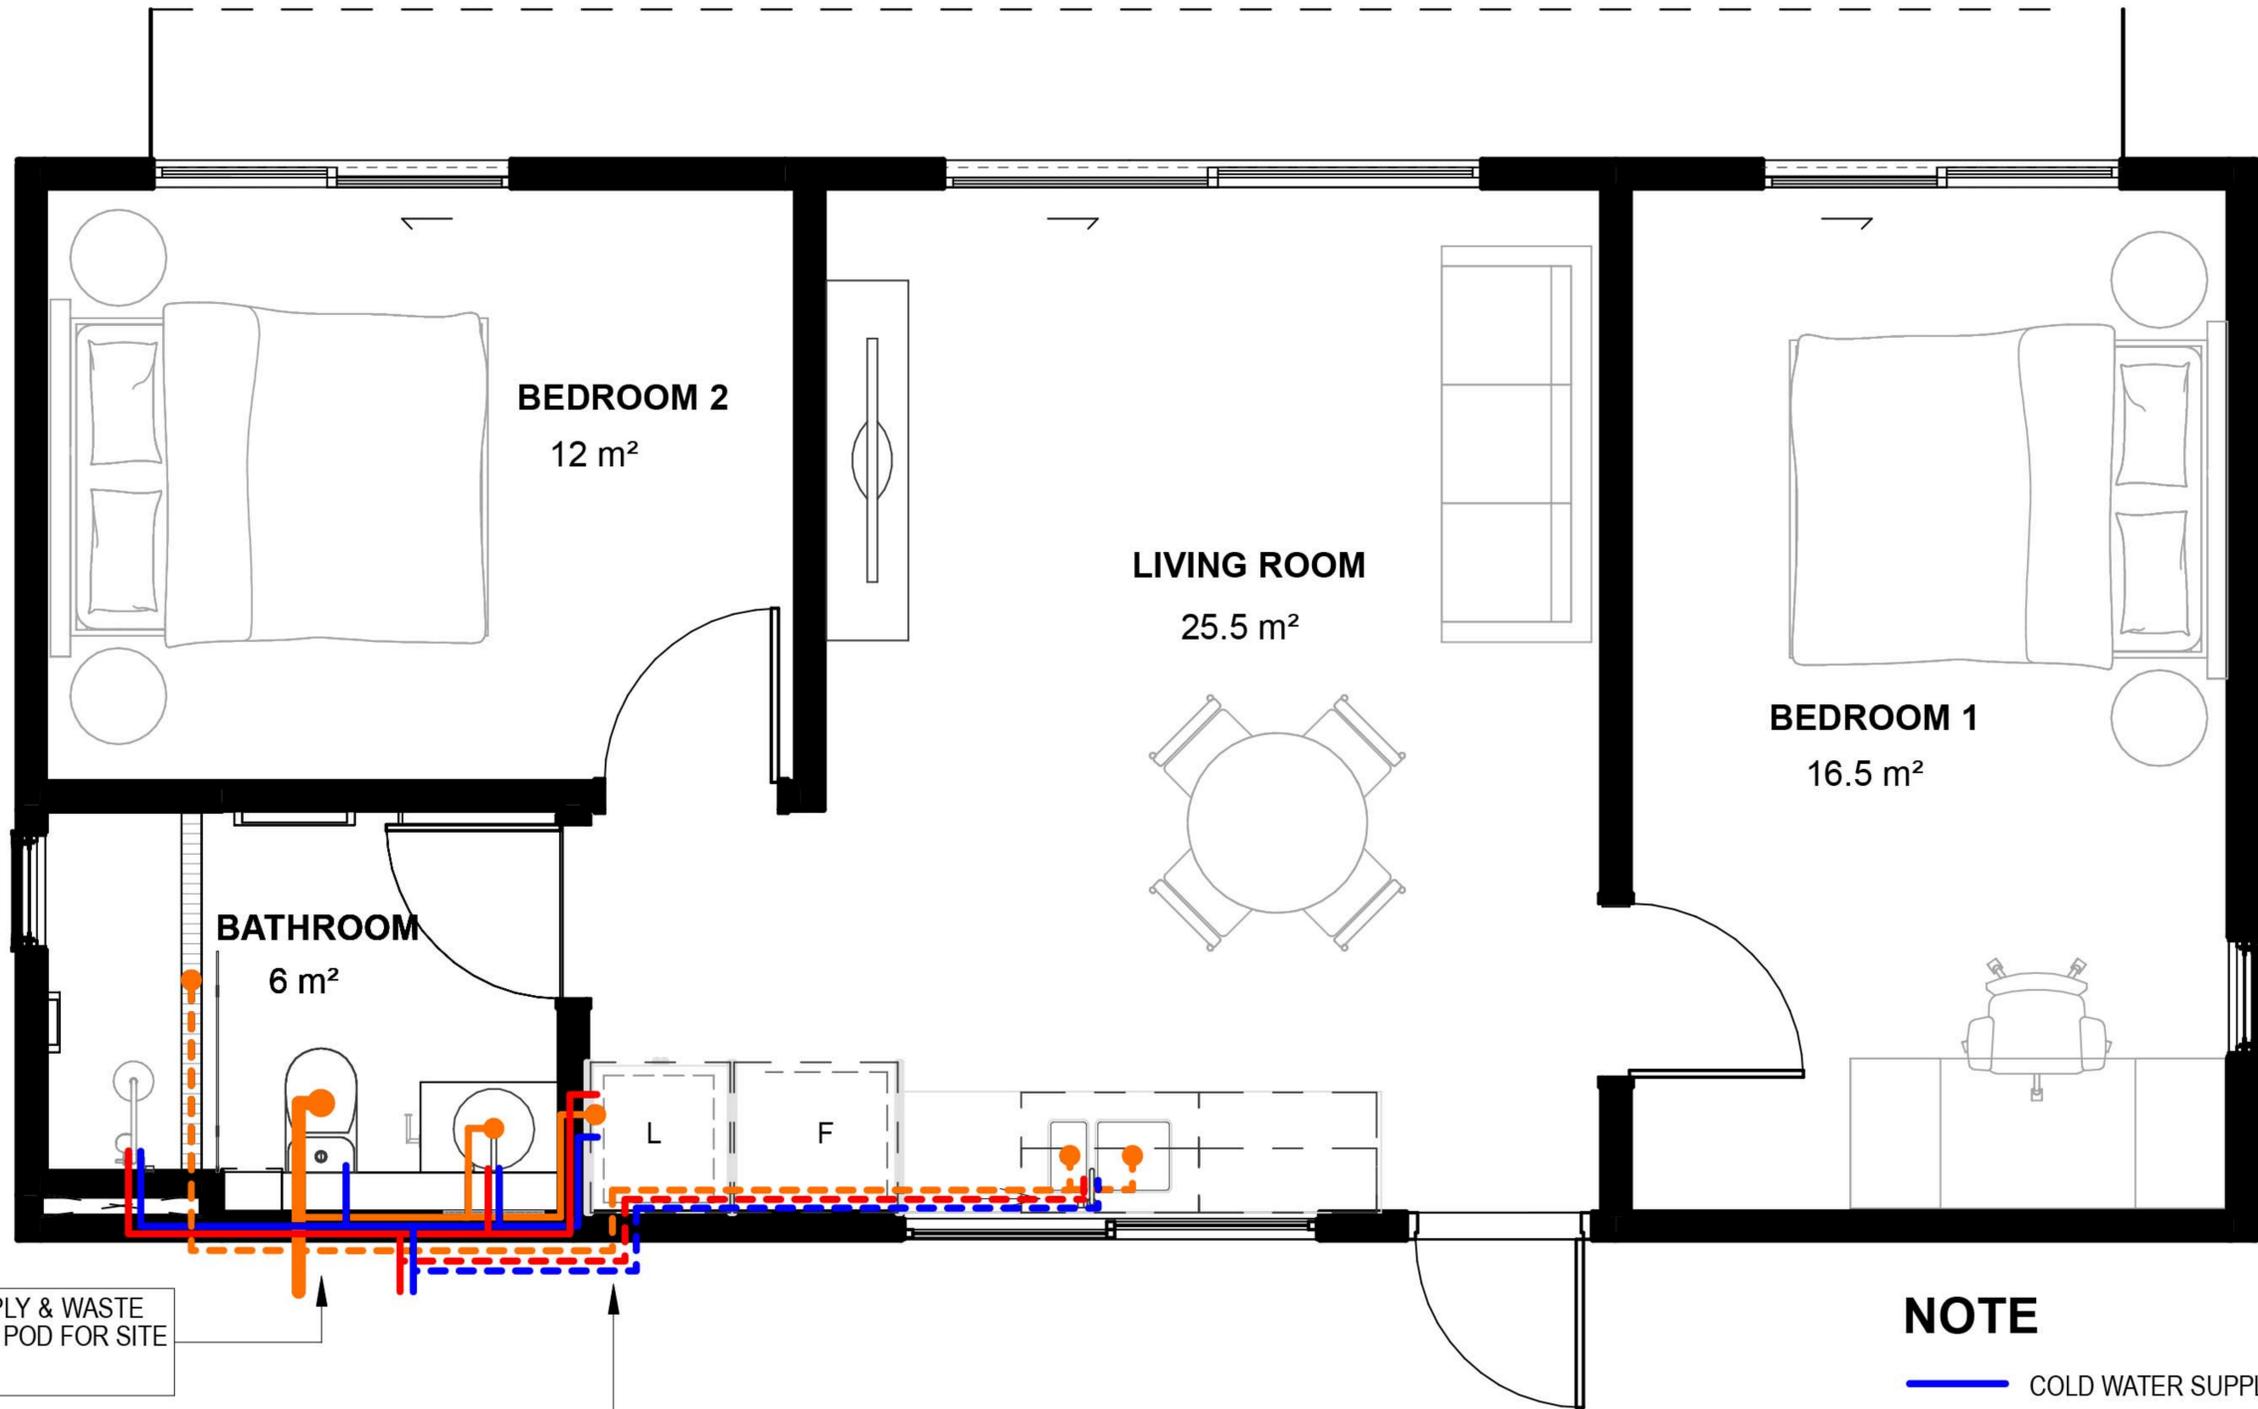

HOT/COLD WATER SUPPLY & WASTE  
PIPES TERMINATE BELOW POD FOR SITE  
CONNECTION

KITCHEN HOT/COLD WATER & WASTE  
TO BE INSTALLED ON SITE UNDER  
FLOOR

### NOTE

- COLD WATER SUPPLY DN15 (21.2mm OD)
- HOT WATER SUPPLY DN15 (21.2mm OD)
- WASTE DN50 (60.2mm OD)
- WASTE DN100 (114.1mm OD)
- (DASH) ON SITE INSTALLATION

# 1 ELECTRICAL PLAN - DA

1 : 50



## SYMBOLS - FIXTURES


## NOTES

- UDL1 WALL MOUNTED FITTING
- DL1 FEATURE DOWN LIGHT
- DL2 RECESSED DOWN LIGHT
- UDL1 SMOKE ALARM
- SA1 WALL MOUNTED UP DOWN LIGHT
- SA POSITIONING PER STATE LEGISLATION

- BATHROOM EXTRACT FAN
- LIGHT SWITCH
- GENERAL POWER OUTLET (GPO)
- KITCHEN STRIP LIGHT
- PROVISION FOR FUTURE FAN

- CCT01: FRONT DOOR WALL LIGHTS
- CCT02: LIVING ROOM DOWNLIGHTS
- CCT03: LIVING ROOM CEILING FAN
- CCT04: KITCHEN DOWNLIGHTS
- CCT05: BACK DOOR WALL LIGHT
- CCT06: KITCHEN STRIP LIGHT

- CCT07: BEDROOM 1 DOWNLIGHTS
- CCT08: BEDROOM 1 CEILING FAN
- CCT09: BEDROOM 2 DOWNLIGHTS
- CCT10: BEDROOM 2 CEILING FAN
- CCT11: BATHROOM DOWNLIGHTS
- CCT12: BATHROOM WALL LIGHTS

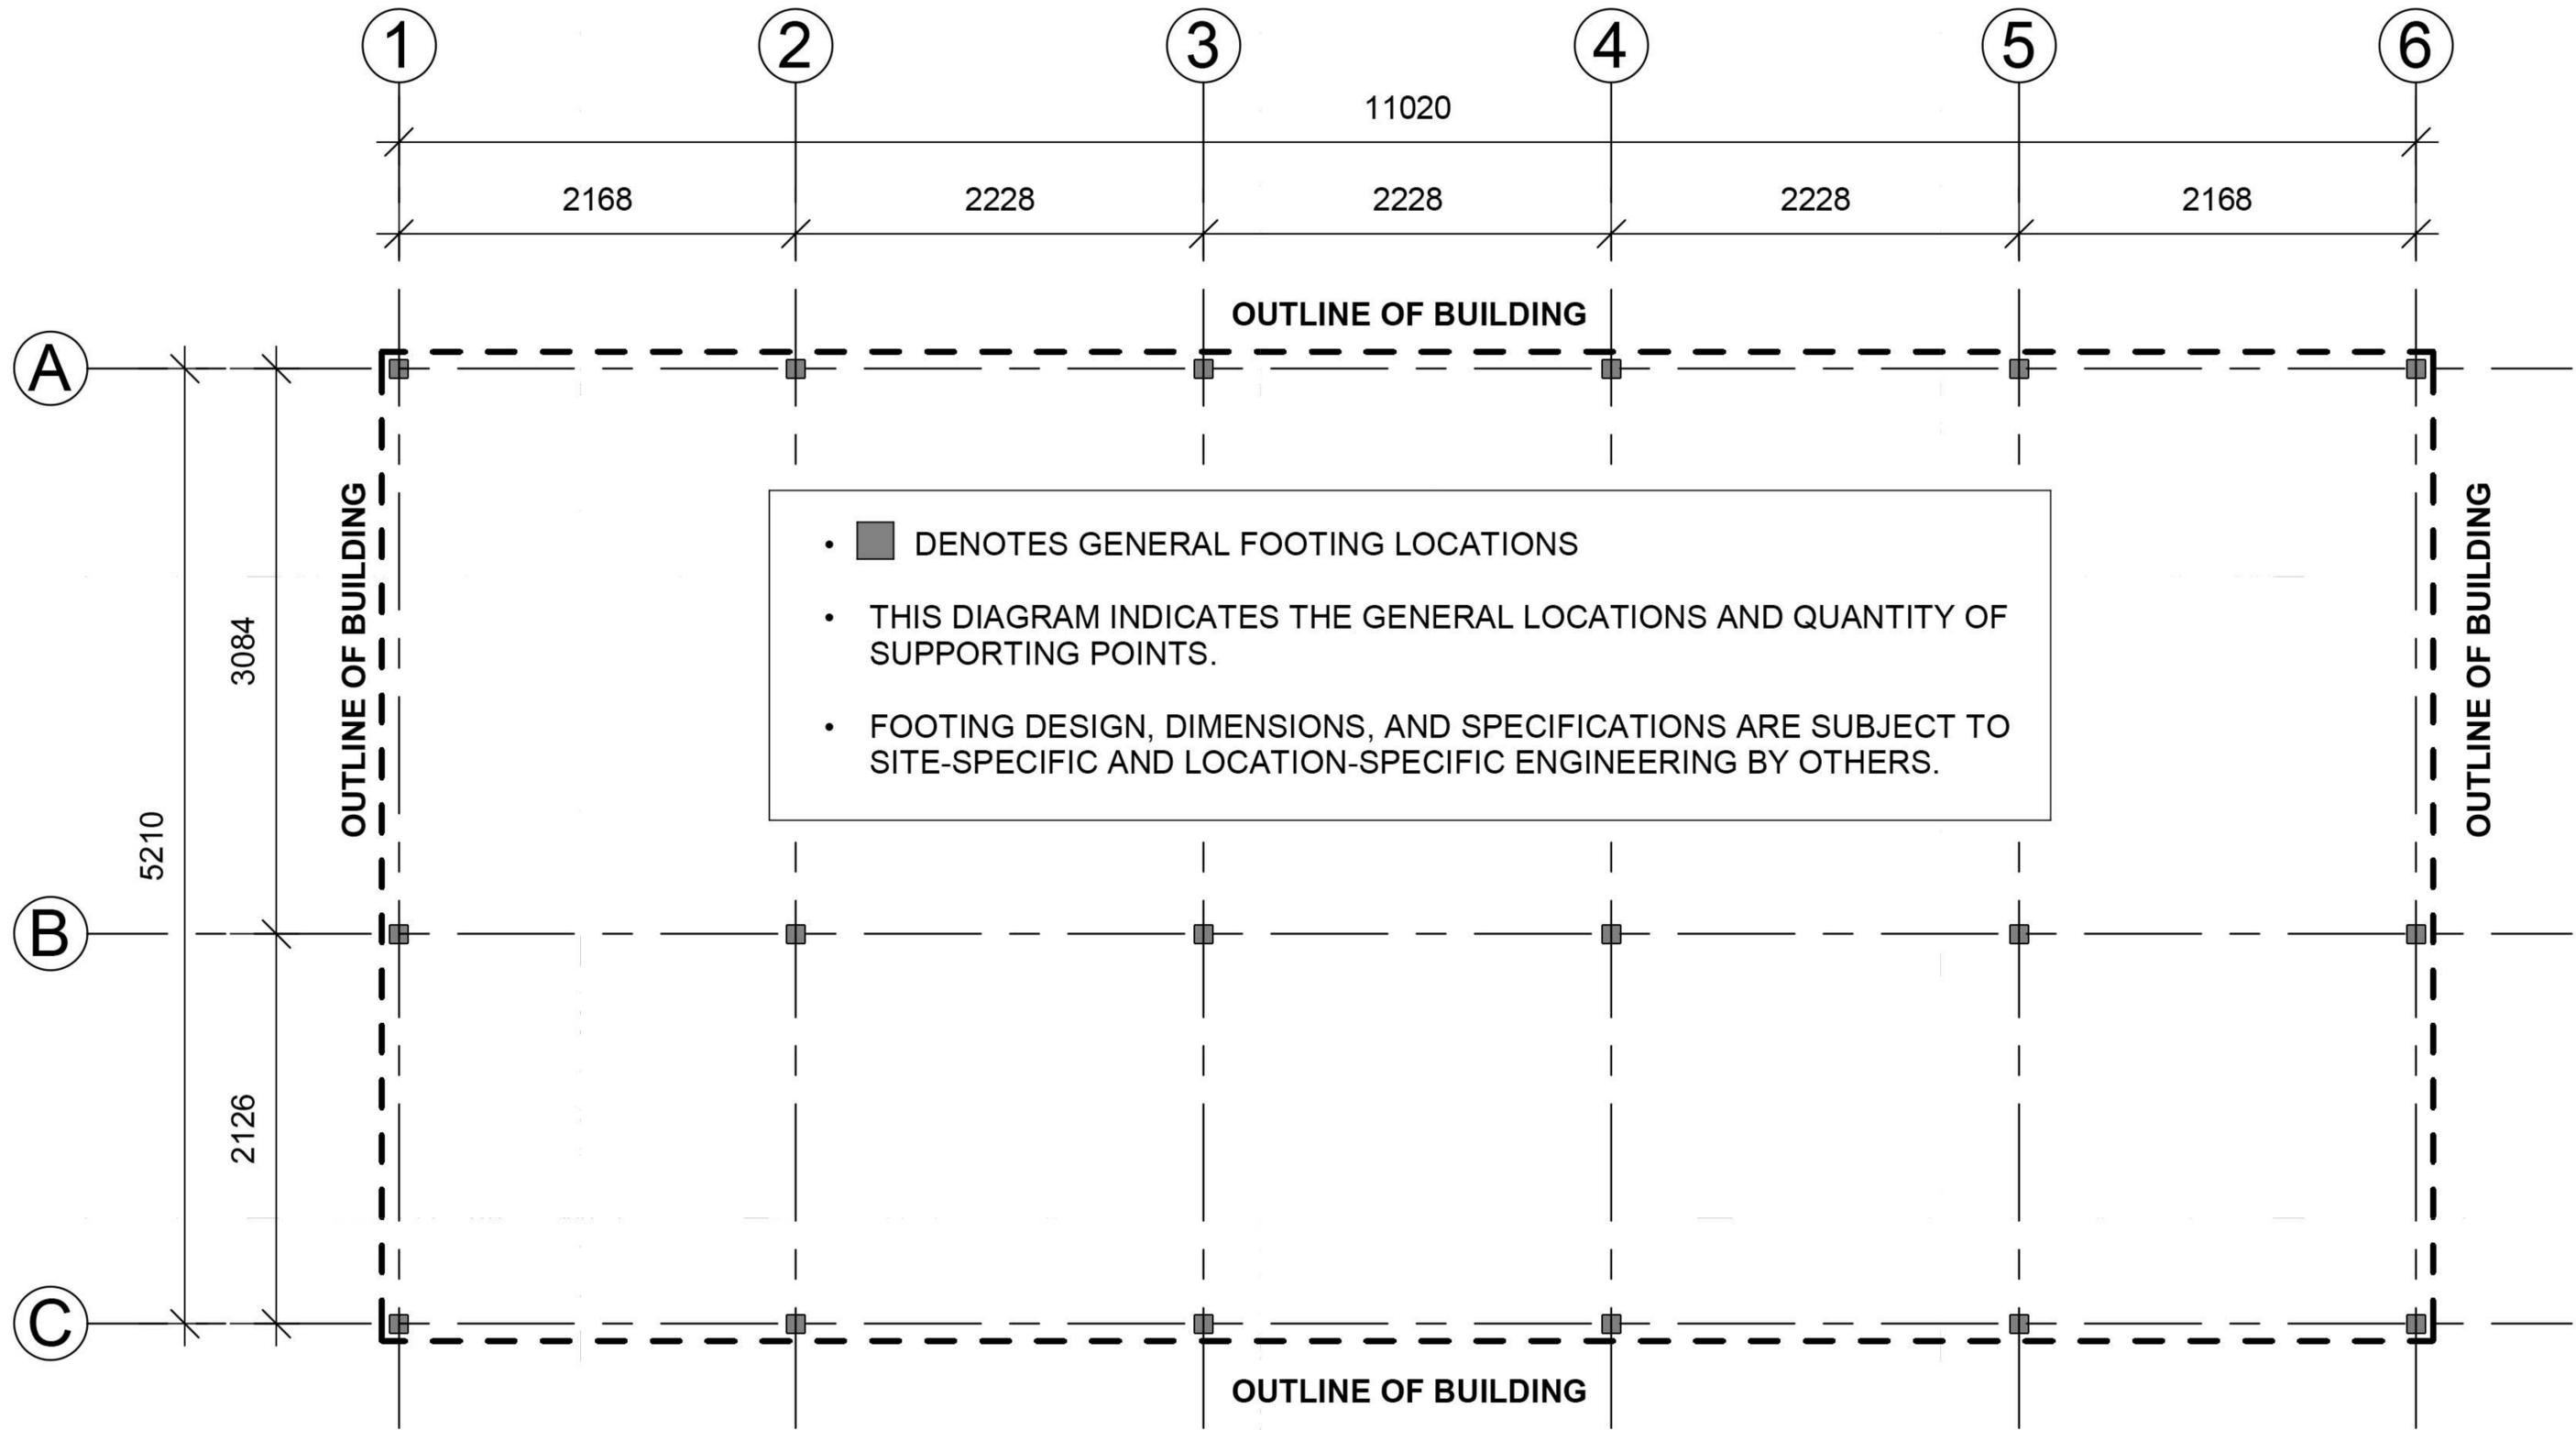

# 1 | FOOTINGS DIAGRAM

SCALE: 1 : 50